

LICENSEABLE AREA
 • FIRE EXTINGUISHERS

First Floor and Lower Roof Plan

SCALE 1:50 @ A1



1. ALL DIMENSIONS TO BE CHECKED ON SITE PRIOR TO COMMENCEMENT OF WORKS. THIS DRAWING AND DESIGN SHALL NOT BE CONSIDERED VALID WITHOUT THE SIGNATURE AND SEAL OF THE REGISTERED ELECTRICAL ENGINEER (SEE DRAWING FOR SIGNATURE AND SEAL). THIS DRAWING IS THE PROPERTY OF MUGALUK SPORTS PITCH CONSULTANTS. IT IS TO BE USED ONLY FOR THE PROJECT AND SITE SPECIFIC PURPOSES DESCRIBED HEREIN. IT IS NOT TO BE REPRODUCED OR TRANSMITTED IN ANY FORM OR BY ANY MEANS, ELECTRONIC OR MECHANICAL, INCLUDING PHOTOCOPYING, RECORDING, OR BY ANY INFORMATION STORAGE AND RETRIEVAL SYSTEM. ALL DIMENSIONS SHOULD BE TAKEN TO THE FACE UNLESS OTHERWISE SPECIFIED. HANDING TO BE GIVEN TO THE CONTRACTOR.


HEALTH AND SAFETY NOTE

ALL PERSONNEL SHOULD BE AWARE OF THE HAZARDOUS AND HIGH VOLTAGE AREAS SHOWN ON THIS DRAWING AND TAKE APPROPRIATE PRECAUTIONS.

- Existing IC
- Existing Overhead electric duct
- New 100mm dia. electric duct
- DB
- New electric duct box chamber
- Cabinet location
- FL
- Floodlight

Cable connection to new Equipment store

**PLAN OF
GROUNDS / PLAYING
FIELDS
SHOWING
CONSUMPTION AREA.**

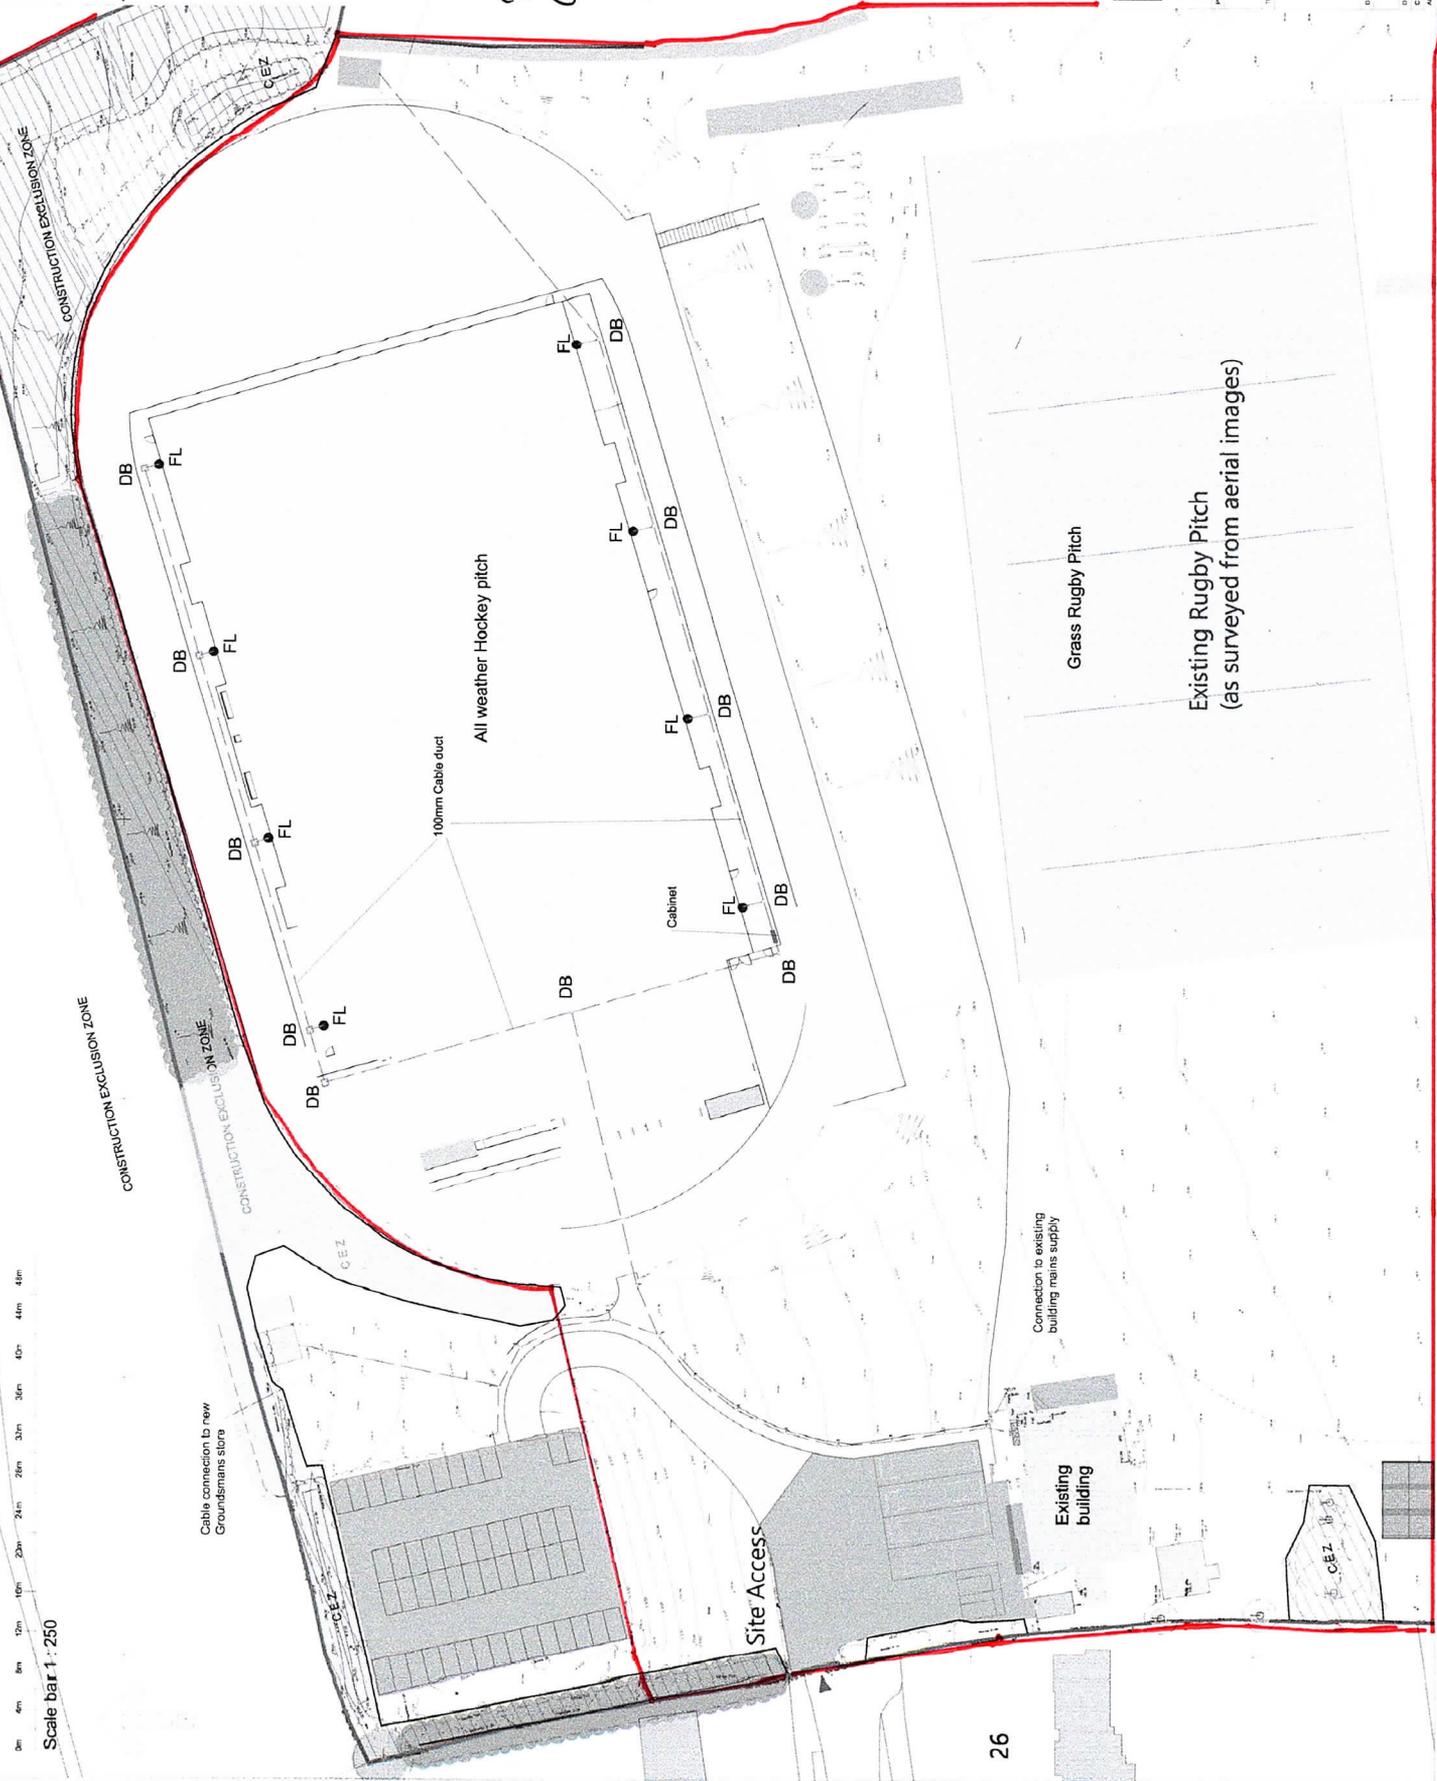

MUGALUK
SPORTS PITCH CONSULTANTS
LEIX RDP, E. +44 (0) 1509 504205 F. +44 (0) 1509 504220
PROJECT TITLE: URNFIELD SPORTS GROUND MUK2896
DRAWN BY: MUK2896-07
CHECKED BY: NTS
DATE: 17/01/22
SCALE: A1

PROPOSED DUCT LAYOUT

DRAWING NO.	MUK2896-07	REV.	A	SCALE	NTS
DRAWN BY	MUK2896-07	DATE	17/01/22	CHECKED BY	NTS
CHECKED BY	NTS	DATE		SCALE	A1
PROJECT TITLE	URNFIELD SPORTS GROUND	DRAWING NO.	MUK2896		